


PROPOSED LIVERPOOL BOUND PLATFORM ROOF & CANOPY PLAN

SCALE 1:50

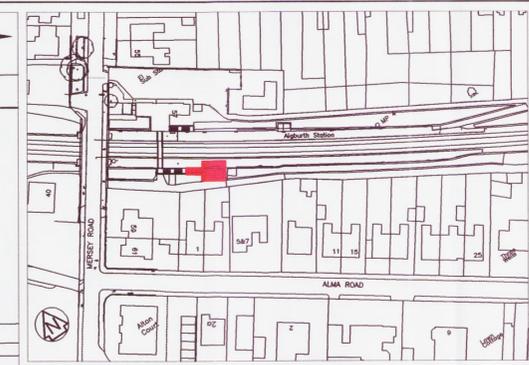


LOCATION PLAN

SCALE 1:1250


LEGEND/NOTES
THIS DRAWING IS TO BE READ IN CONJUNCTION WITH AND FORMS PART OF THE PROJECT DOCUMENTS LISTED BELOW:

CIVILS DESIGN SUBMISSION	
BDG0117/CIV/FORM2	STATEMENT OF DESIGN INTENT
BDG0117/CIV/FORM3	CERTIFICATE OF DESIGN AND CHECK
BDG0117/CIV/DC	INTERDISCIPLINARY DESIGN CHECK CERTIFICATE
BDG0117/CIV/DR	DESIGNER RISK ASSESSMENT
BDG0117/CIV/ECL	ENVIRONMENTAL CHECKLIST
BDG0117/CIV/SPEC	NBS SPECIFICATION / MODEL CLAUSES
BDG0117/DRG/A001	EXISTING GA PLANS, ELEVATIONS & SECTIONS
BDG0117/DRG/A002	PROPOSED ROOF PLANS & ELEVATIONS
BDG0117/DRG/A003	PROPOSED GENERAL ARRANGEMENT PLAN & SECTIONS
BDG0117/DRG/A004	TYPICAL DETAILS SHEET 1
BDG0117/DRG/A005	TYPICAL DETAILS SHEET 2
M&E DESIGN SUBMISSION	
BDG0117/ENG/FORM2	STATEMENT OF DESIGN INTENT
BDG0117/ENG/FORM3	CERTIFICATE OF DESIGN AND CHECK
BDG0117/ENG/DC	INTERDISCIPLINARY DESIGN CHECK CERTIFICATE
BDG0117/CIV/DR	DESIGNER RISK ASSESSMENT
BDG0117/DRG/E001	EXISTING LIGHTING LAYOUT AND DISTRIBUTION SCHEMATIC
BDG0117/DRG/E002	PROPOSED LIGHTING LAYOUT AND DISTRIBUTION SCHEMATIC
	LNW ENGINEERING SPECIFICATION FOR ELECTRICAL INSTALLATIONS

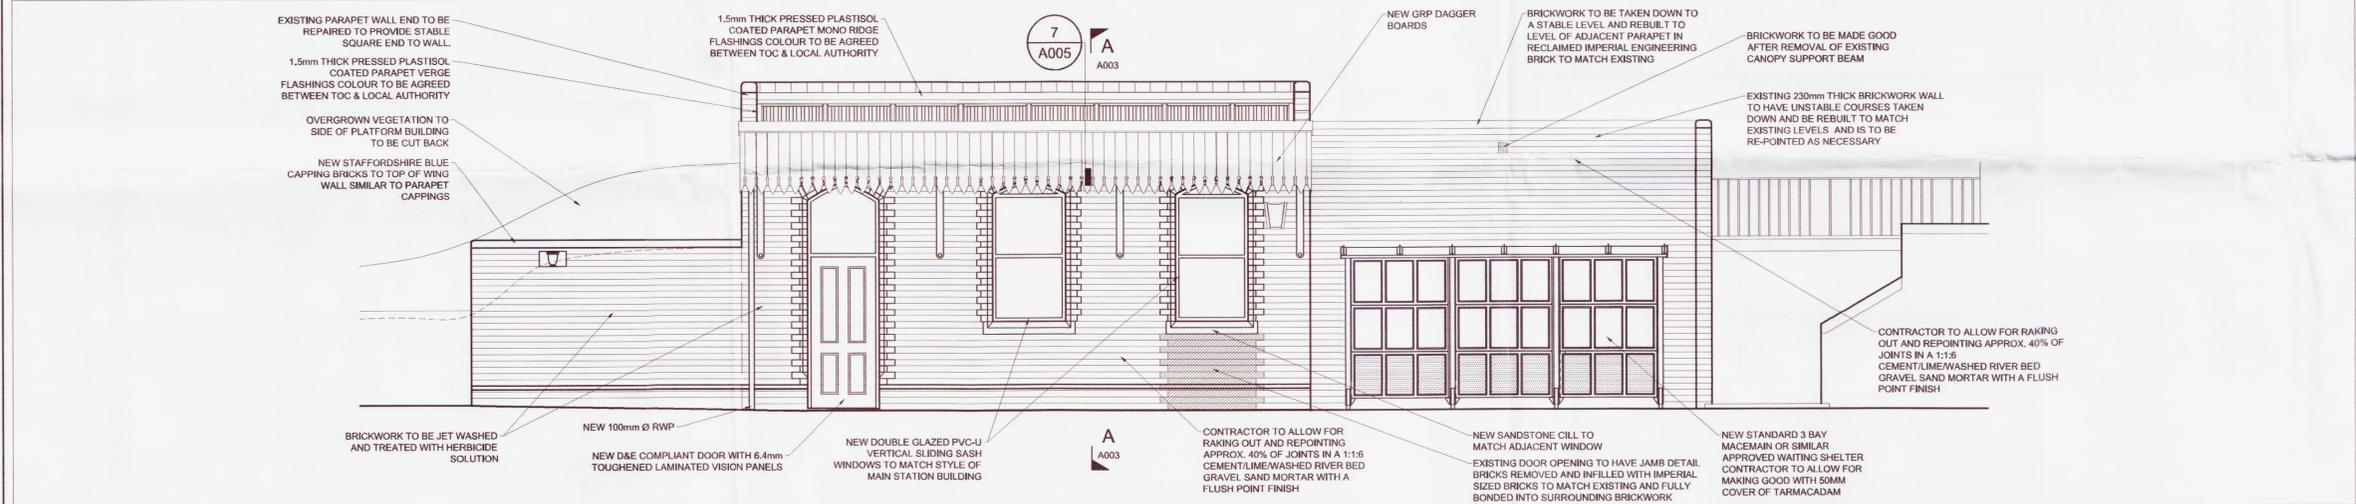


PLATFORM BUILDING TRACK SIDE ELEVATION

SCALE 1:50

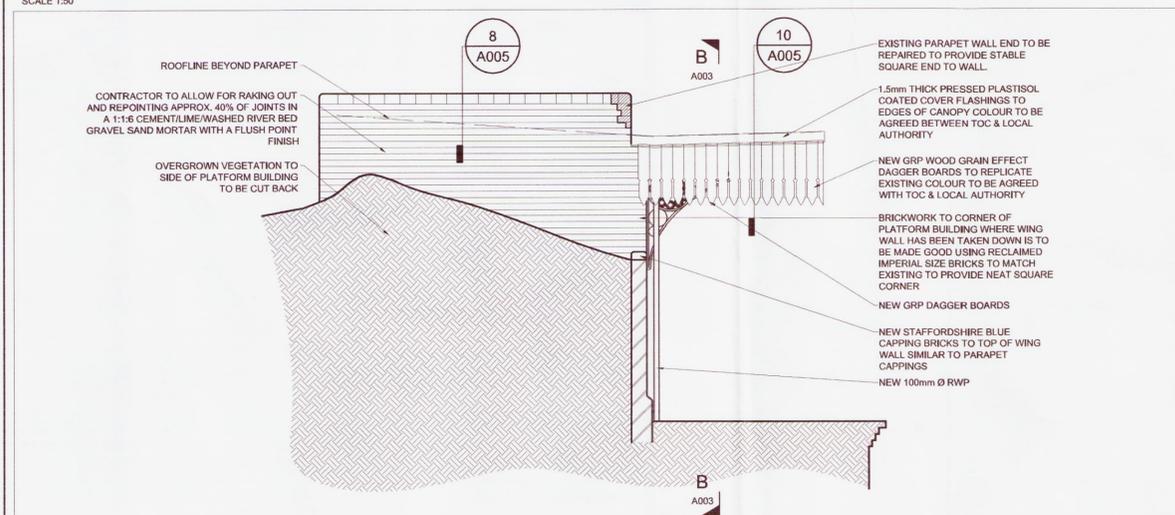

PLATFORM BUILDING CRESSINGTON END ELEVATION

SCALE 1:50

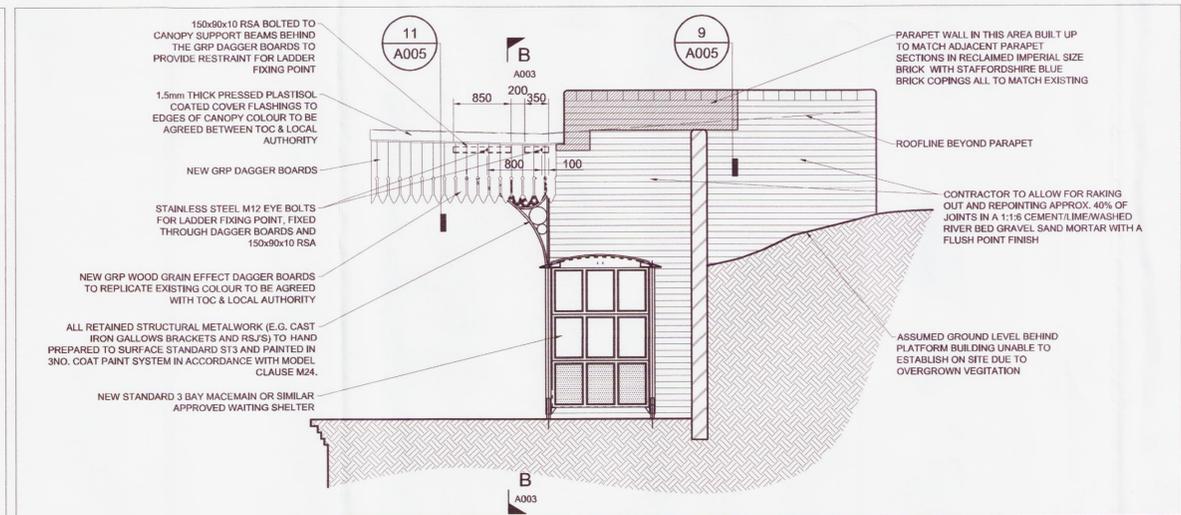

PLATFORM BUILDING ST. MICHAEL'S END ELEVATION

SCALE 1:50

P01	06/08/2012	DRAFT ISSUE		DPC	JP	JW
REV	DATE	DESCRIPTION OF REVISIONS		DRAWN	CHKD	APPRD

SAFETY HEALTH AND ENVIRONMENTAL INFORMATION

THE HAZARDS AND RISKS ASSOCIATED WITH THE WORKS SHOWN ON THIS DRAWING AND DESCRIBED IN THE SCHEDULE OF WORKS ARE CONSIDERED TO BE WITHIN THE REASONABLE, NORMAL AND ACCEPTABLE LIMITS FOR GENERAL BUILDING AND MAINTENANCE WORKS. PLEASE REFER TO DESIGNER RISK ASSESSMENT
DOCUMENT REF: BDG0117/DR

STATUS
DRAFT ISSUE



INFRASTRUCTURE PROJECTS LNW
SQUARE ONE
4 TRAVIS STREET
MANCHESTER
M1 2NY

PROJECT: BDG0117

AIGBURTH CANOPY REFURBISHMENT

DRAWING TITLE

PROPOSED ROOF PLANS & ELEVATIONS

DESIGNED	J.POWELL	SIGNED		DATE	23/07/2012
DRAWN	D.CARVER	SIGNED		DATE	23/07/2012
CHECKED	S.ELLIS	SIGNED		DATE	28/07/2012
APPROVED	J.WINSTANLEY	SIGNED		DATE	28/07/2012
SCALE(S) AT A1 SHEET SIZE 894 X 841	ELR & MILEAGE		HXS1 3.1716		
1:100, 1:1250					
ALTERNATIVE REFERENCE	123351/DRG/A002				

DRAWING NUMBER
BDG0117/DRG/A002

REVISION
P01

12 PM 27 12

23 OCT 2012