




7 ENLARGED CANOPY SECTION & DETAILS
SCALE: 1:10

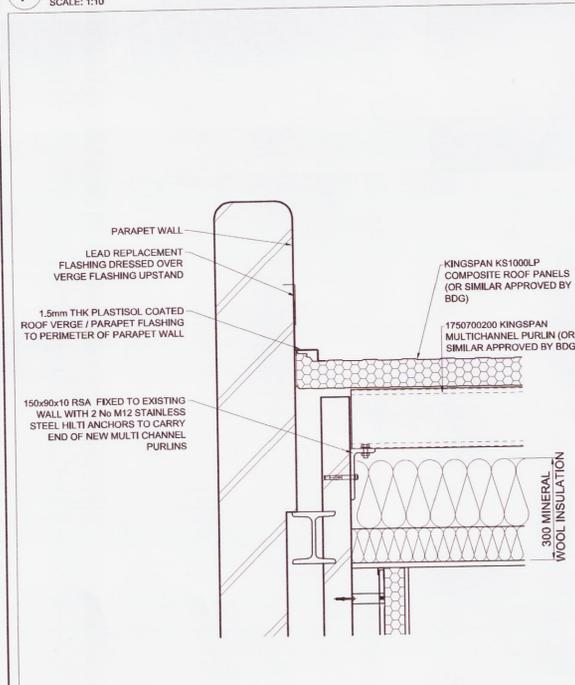


8 PARAPET VERGE DETAIL - CRESSINGTON END
SCALE: 1:10

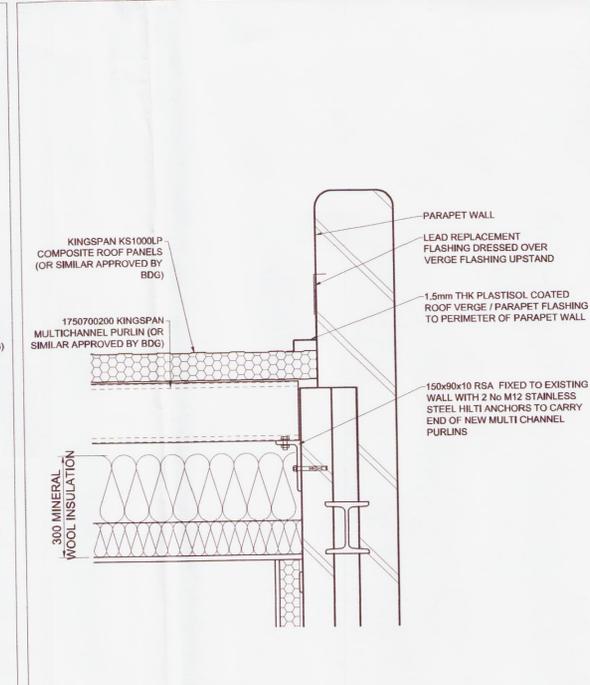

9 PARAPET VERGE DETAIL - ST. MICHAEL'S END
SCALE: 1:10

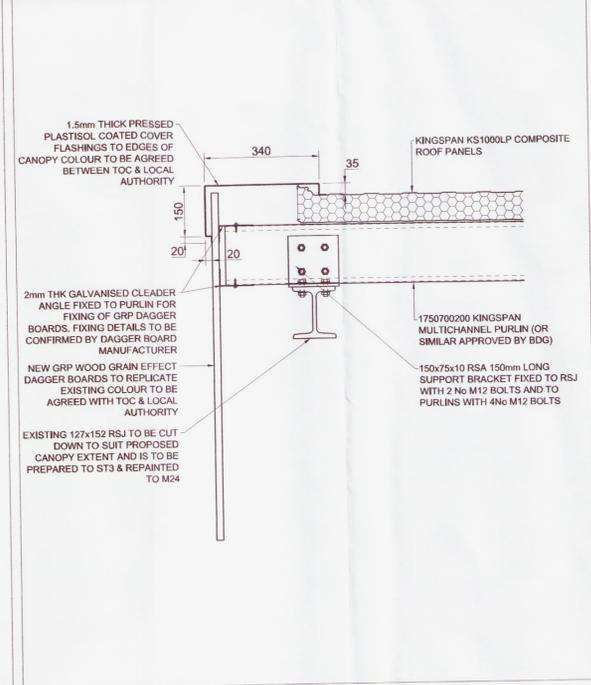

10 CANOPY VERGE DETAIL - CRESSINGTON END
SCALE: 1:10

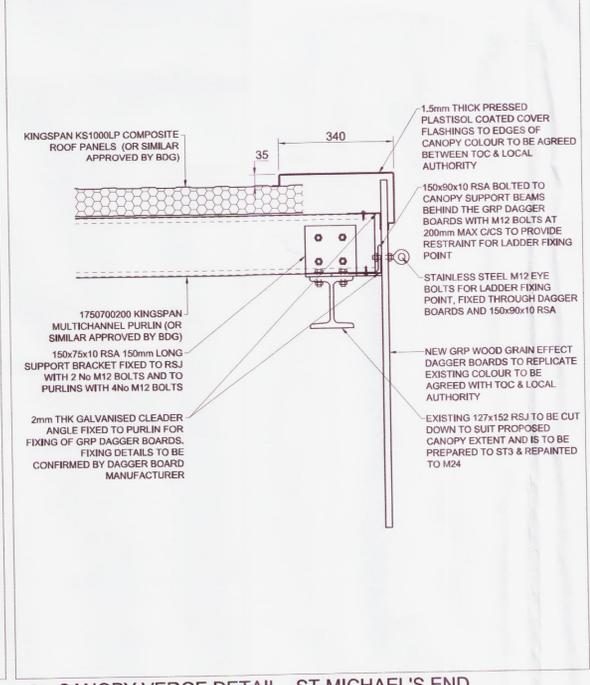

11 CANOPY VERGE DETAIL - ST. MICHAEL'S END
SCALE: 1:10

LEGEND/NOTES
THIS DRAWING IS TO BE READ IN CONJUNCTION WITH AND FORMS PART OF THE PROJECT DOCUMENTS LISTED BELOW:

CIVILS DESIGN SUBMISSION	STATEMENT OF DESIGN INTENT
BDG0117/CIV/FORM2	CERTIFICATE OF DESIGN AND CHECK
BDG0117/CIV/FORM3	INTERDISCIPLINARY DESIGN CHECK CERTIFICATE
BDG0117/CIV/DC	DESIGNER RISK ASSESSMENT
BDG0117/CIV/DRA	ENVIRONMENTAL CHECKLIST
BDG0117/CIV/ECL	NBS SPECIFICATION / MODEL CLAUSES
BDG0117/CIV/SPEC	EXISTING GA PLANS, ELEVATIONS & SECTIONS
BDG0117/DRG/A001	PROPOSED ROOF PLANS & ELEVATIONS
BDG0117/DRG/A002	PROPOSED GENERAL ARRANGEMENT PLAN & SECTIONS
BDG0117/DRG/A003	TYPICAL DETAILS SHEET 1
BDG0117/DRG/A004	TYPICAL DETAILS SHEET 2

M&E DESIGN SUBMISSION	STATEMENT OF DESIGN INTENT
BDG0117/ENG/FORM2	CERTIFICATE OF DESIGN AND CHECK
BDG0117/ENG/FORM3	INTERDISCIPLINARY DESIGN CHECK CERTIFICATE
BDG0117/ENG/DC	DESIGNER RISK ASSESSMENT
BDG0117/ENG/DRA	EXISTING LIGHTING LAYOUT AND DISTRIBUTION SCHEMATIC
BDG0117/DRG/E001	PROPOSED LIGHTING LAYOUT AND DISTRIBUTION SCHEMATIC
BDG0117/DRG/E002	LNW ENGINEERING SPECIFICATION FOR ELECTRICAL INSTALLATIONS



REV	DATE	DESCRIPTION OF REVISIONS	DPC	JP	JW
P01	06/08/2012	DRAFT ISSUE			

SAFETY HEALTH AND ENVIRONMENTAL INFORMATION

THE HAZARDS AND RISKS ASSOCIATED WITH THE WORKS SHOWN ON THIS DRAWING AND DESCRIBED IN THE SCHEDULE OF WORKS ARE CONSIDERED TO BE WITHIN THE REASONABLE, NORMAL AND ACCEPTABLE LIMITS FOR GENERAL BUILDING AND MAINTENANCE WORKS. PLEASE REFER TO DESIGNER RISK ASSESSMENT DOCUMENT REF: BDG0117/DRA

STATUS: DRAFT ISSUE



PROJECT: BDG0117

AIGBURTH CANOPY REFURBISHMENT

DRAWING TITLE: TYPICAL DETAILS SHEET 2

DESIGNED	SIGNED	DATE
J. POWELL		23/07/2012
D. CARVER		23/07/2012
S. ELLIS		28/07/2012
J. WINSTANLEY		28/07/2012

SCALE(S) AT SHEET SIZE: 594 X 841
1:10
ALTERNATIVE REFERENCE: 123351/DRG/A005

DRAWING NUMBER	REVISION
BDG0117/DRG/A005	P01

12 PM 27 12

23 OCT 2012